


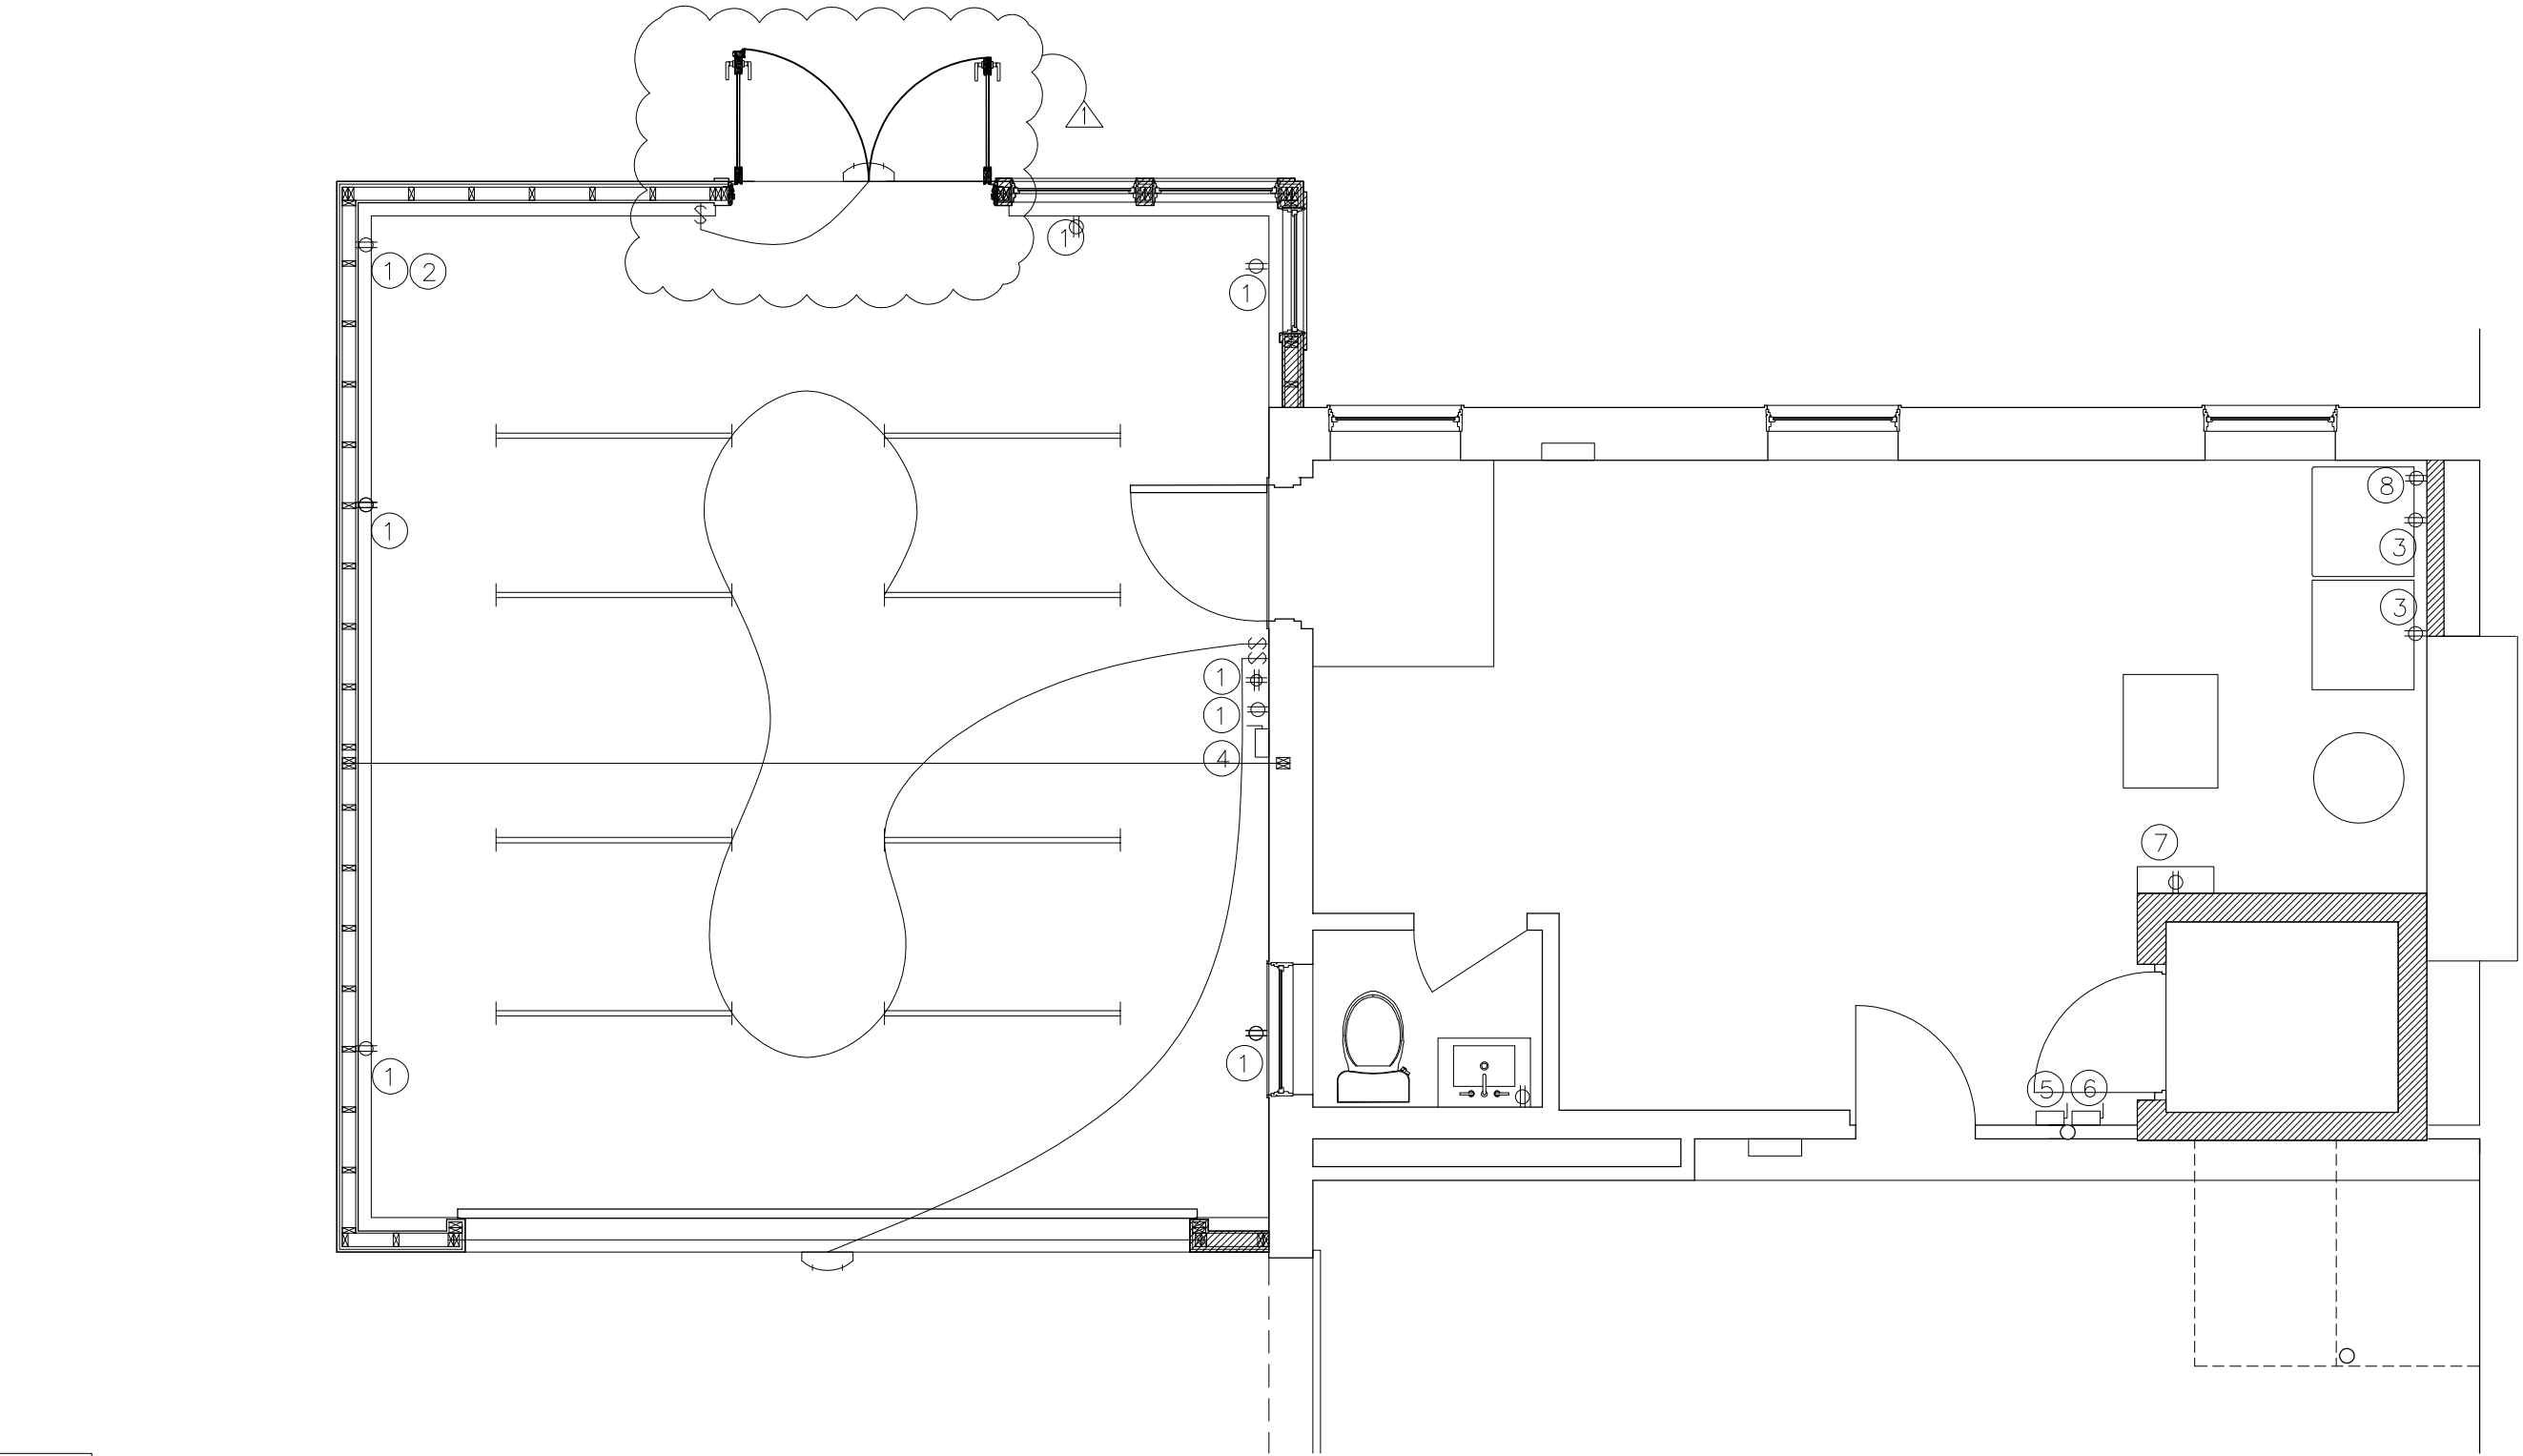


3 GARAGE REFLECTED CEILING PLAN
1/4" = 1'-0" (W/ ELECTRICAL OUTLETS & CONTROLS)

LEGEND OF CEILING & ELECTRICAL FIXTURES:


- 4'-0" 5200 LUMEN INTEGRATED LED WRAP AROUND LIGHT
- WALL MOUNTED DUPLEX ELEC. OUTLET, REFER TO ELEC. OUTLET KEY NOTE FOR MOUNTING HEIGHT.
- WALL MOUNTED QUADPLEX ELEC. OUTLET.
- WALL MOUNTED EXTERIOR FLOOD LIGHT TO BE SELECTED BY OWNER
- ELEC. DISCONNECT (SEE KEYNOTES FOR FURTHER INFO)

ELECTRICAL KEY NOTES:


- LOCATE OUTLET @ 1'-2" AFF.
- DEDICATED 15A BREAKER
- LOCATE OUTLET PER ELEC. APPLIANCE & EQUIPMENT REQUIREMENTS.
- GARAGE/50A 220V DISCONNECT.
- BASEMENT/ 220V ELEVATOR DISCONNECT.
- BASEMENT/110V ELEVATOR LIGHTING DISCONNECT.
- ELEVATOR CONTROLLER
- 120V OUTLET FOR RELOCATED EQUIP. (COORDINATE EXACT LOCATION W/ OWNER)

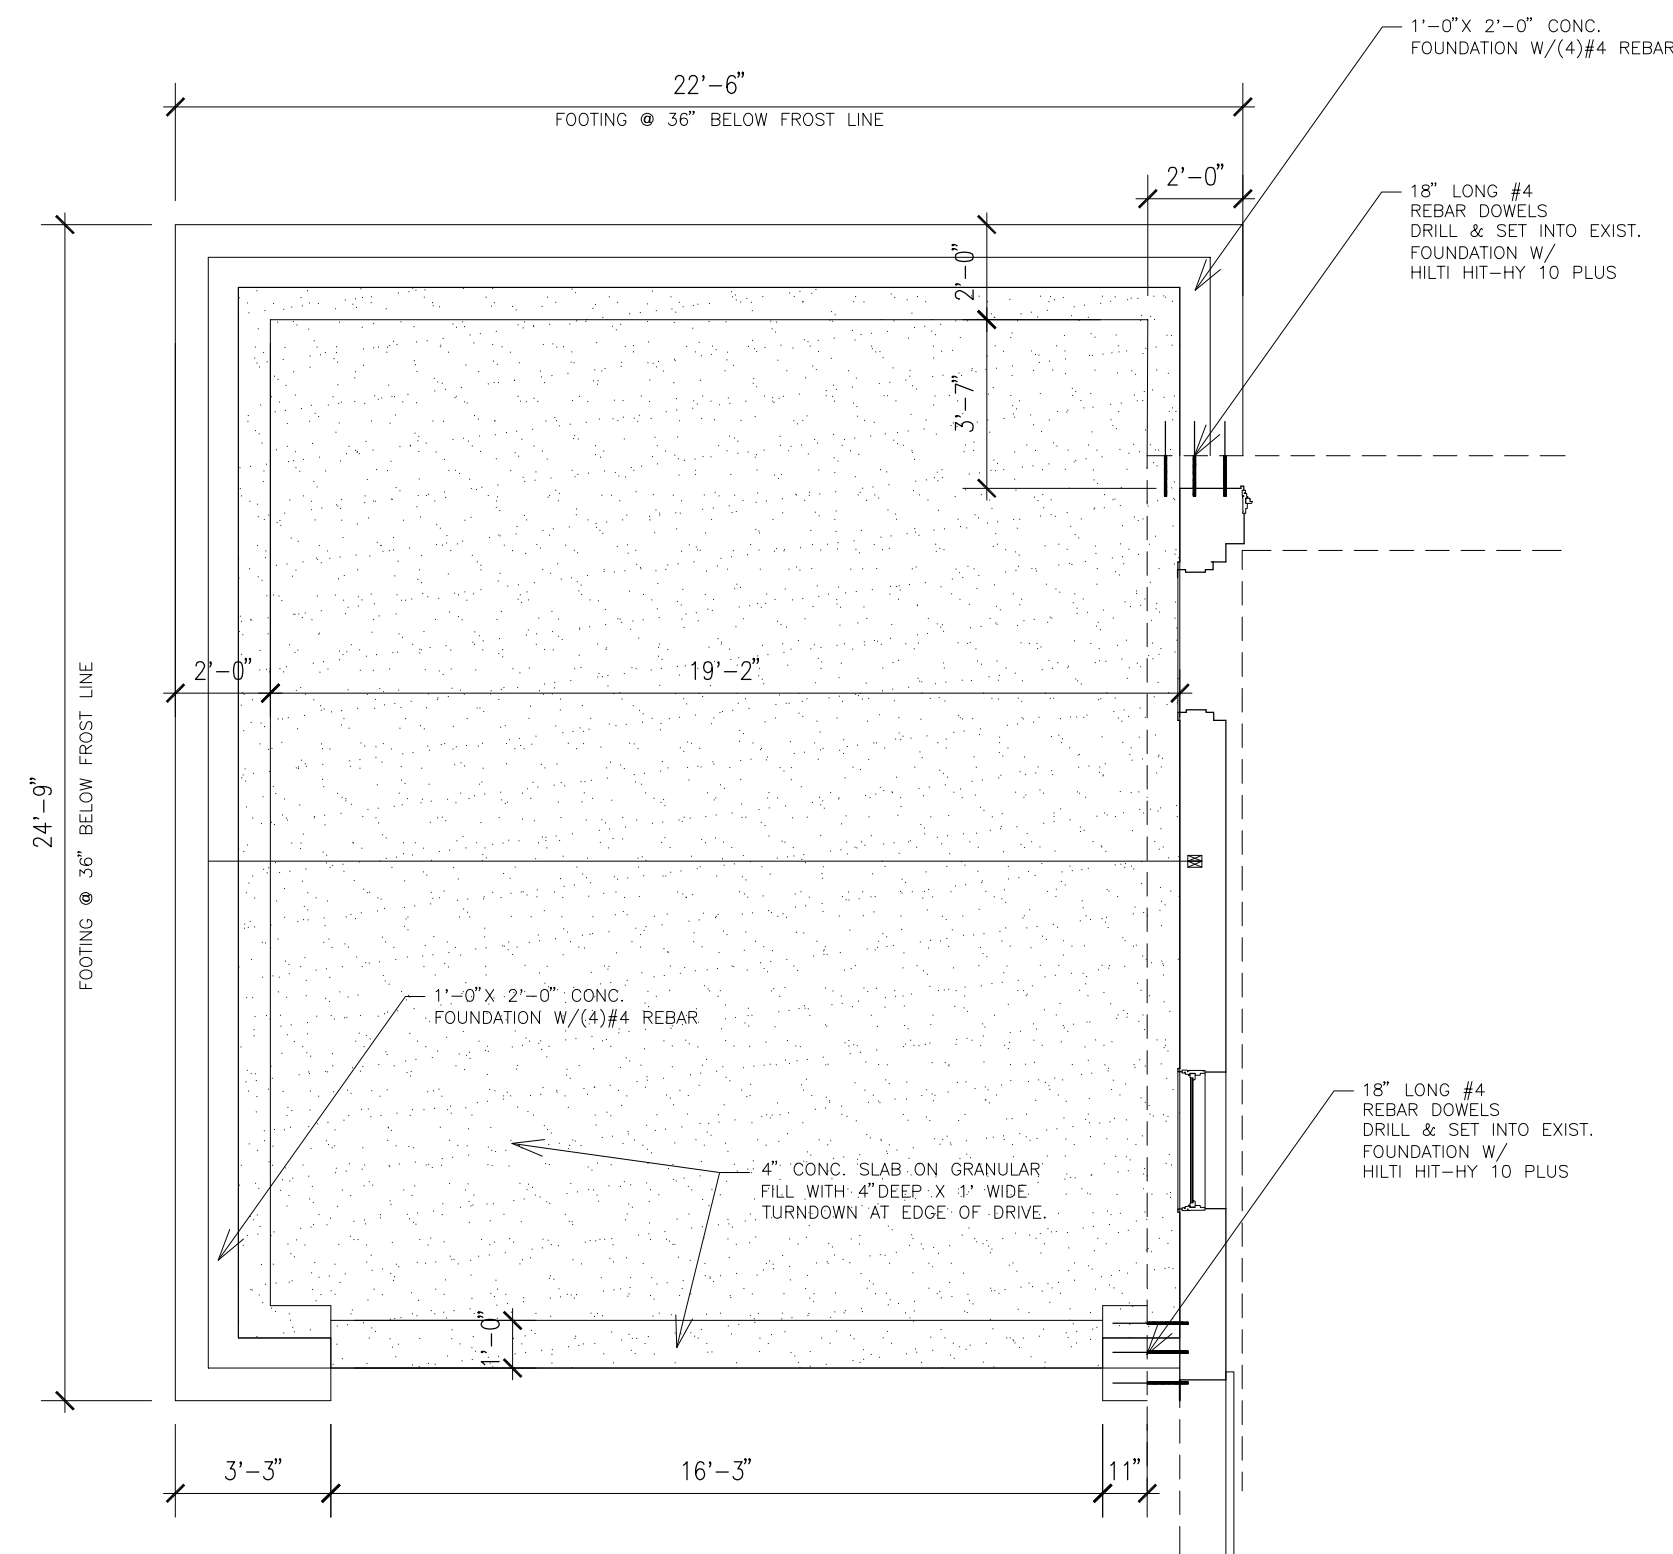

4 GARAGE FOUNDATION PLAN
1/4" = 1'-0"

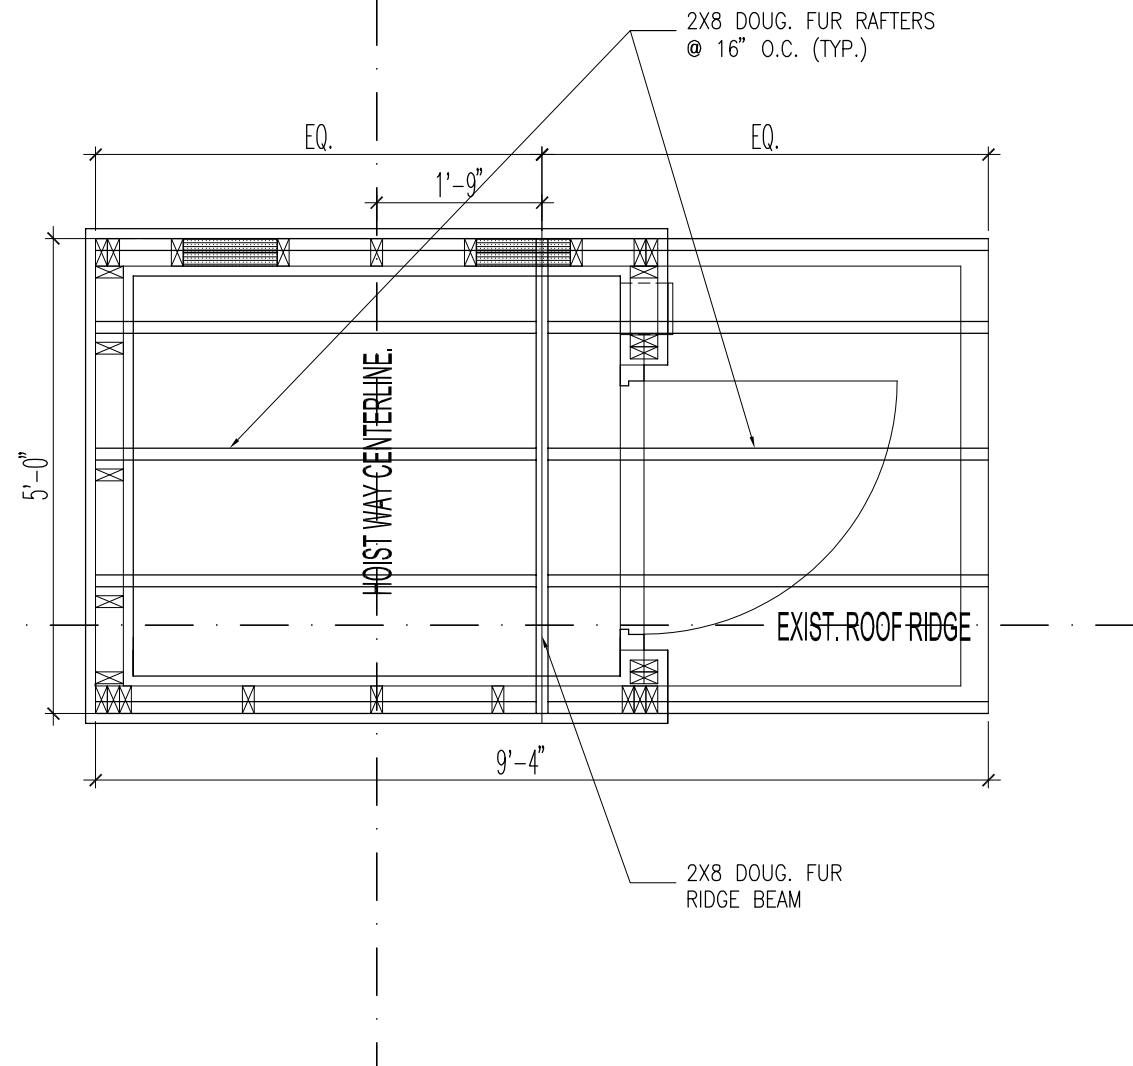

1 ELEVATOR PENTHOUSE FRAMING PLAN
1/2" = 1'-0"

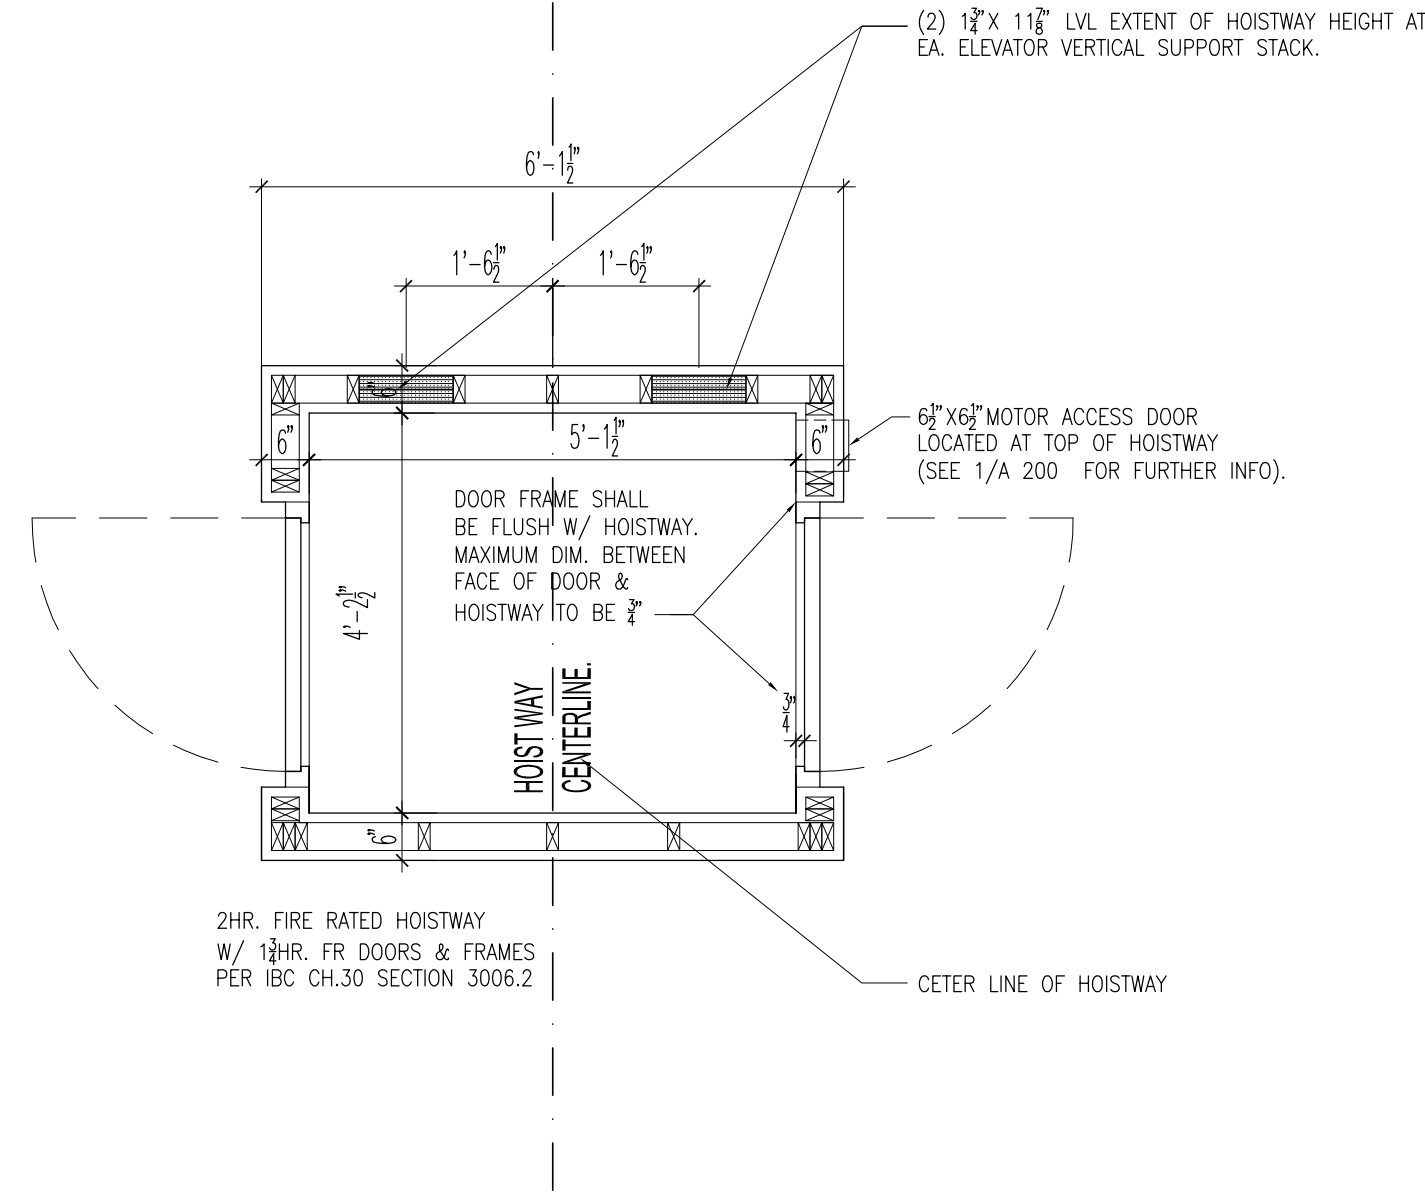


2 ELEVATOR FRAMING PLAN
1/2" = 1'-0"

ELEVATOR NOTES:

- CONTRACTOR TO SUBMIT ELEVATOR DOORS AND FRAMES TO ELEVATOR MFG. REPRESENTATIVE FOR FINAL REVIEW PRIOR TO SECURING ORDER.
- HOISTWAY FRAMING TO BE WITHIN 1/2" OF PLUMB FROM TOP TO BOTTOM. REFER TO ELEVATOR MFG. SHOP DRAWINGS FOR FURTHER HOISTWAY DETAILS.

PLAN

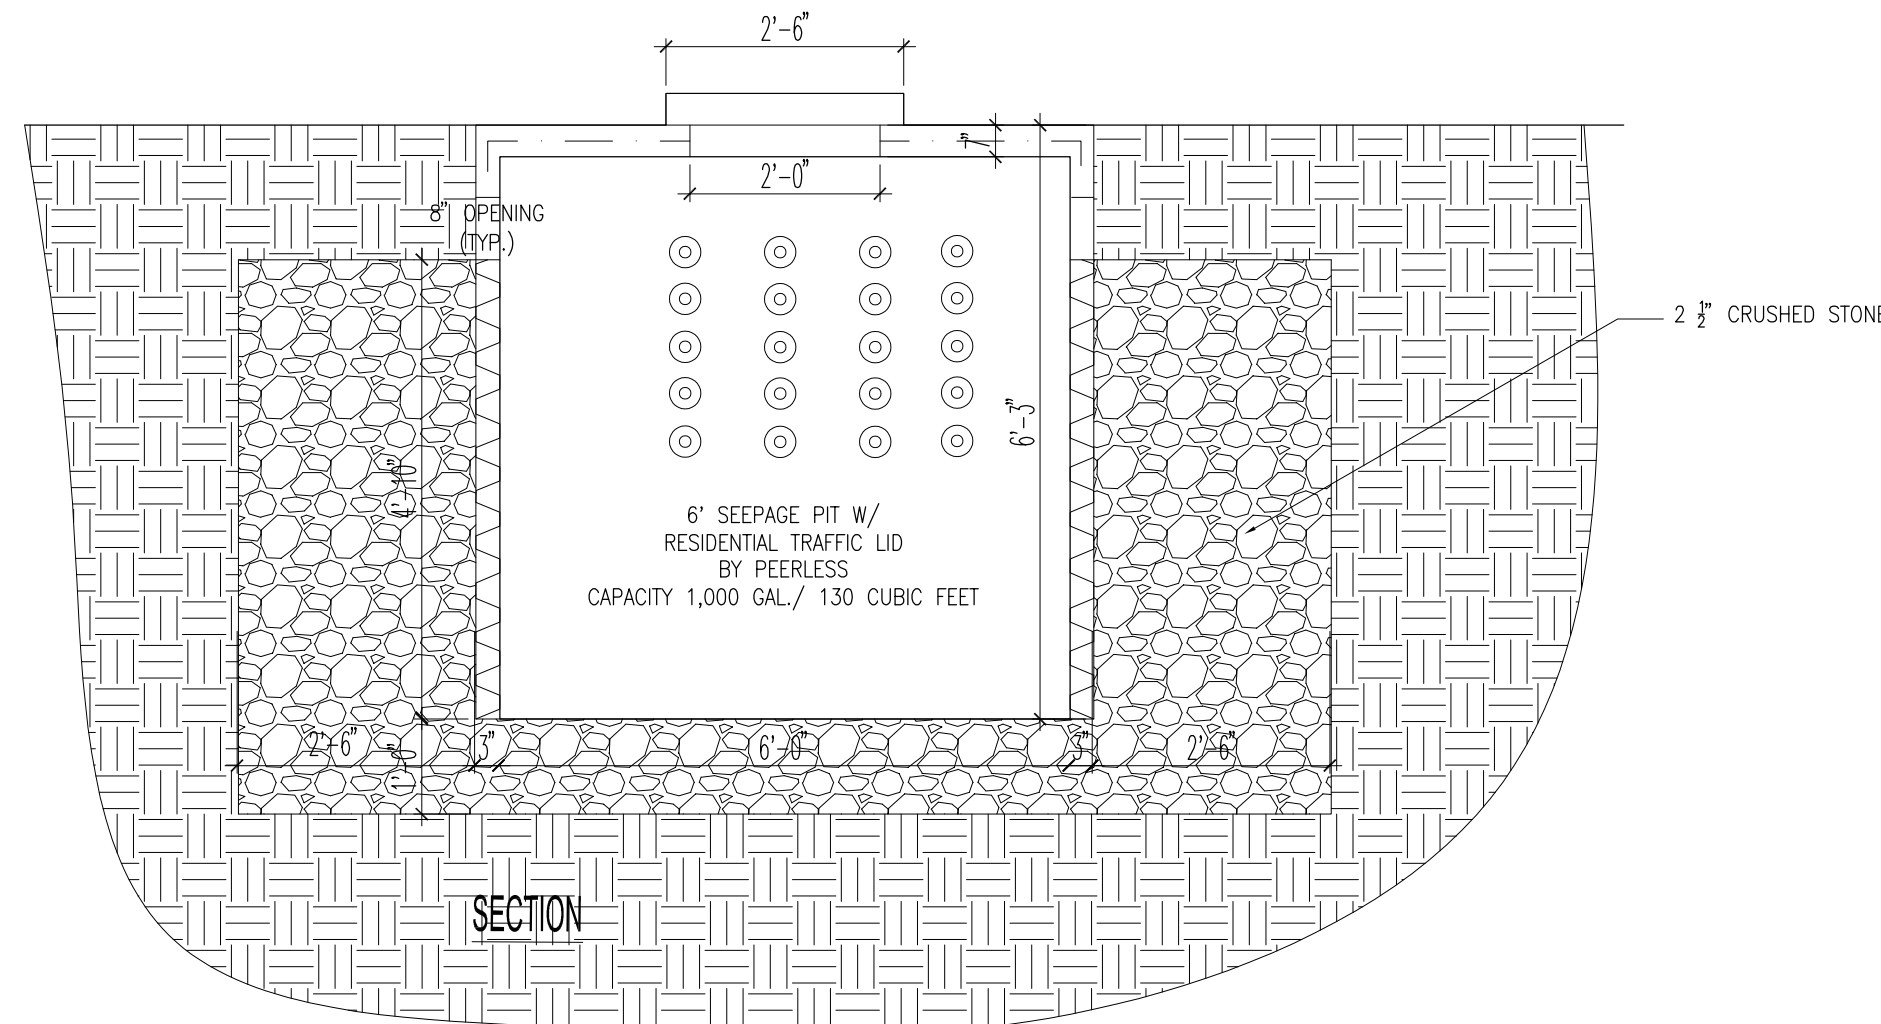

5 DRY WELL DETAIL
1/2" = 1'-0"



BYLO-SHORT RESIDENCE

16 HART DRIVE NORTH, SOUTH ORANGE, NJ 07079 PH 814-321-4824

GINOCCHIO ARCHITECTURE

16 GARRIDGE ROAD WEST ORANGE, NJ 07052 WWW.GINOCCHIOARCH.COM PH 973-669-0692

REVISION:

DATE:	DESCRIPTION:
04/01/21	ZONING BOARD
05/08/21	REV. PER ZONING BOARD COMMENTS

SCALE: AS NOTED

DATE: 03/03/21

JOB: NO:2102

DRAWING TITLE:

ELEVATOR FRAMING PLANS,

ELECTRICAL PLANS & PROJECT NOTES

DRAWING NUMBER:

A 300